

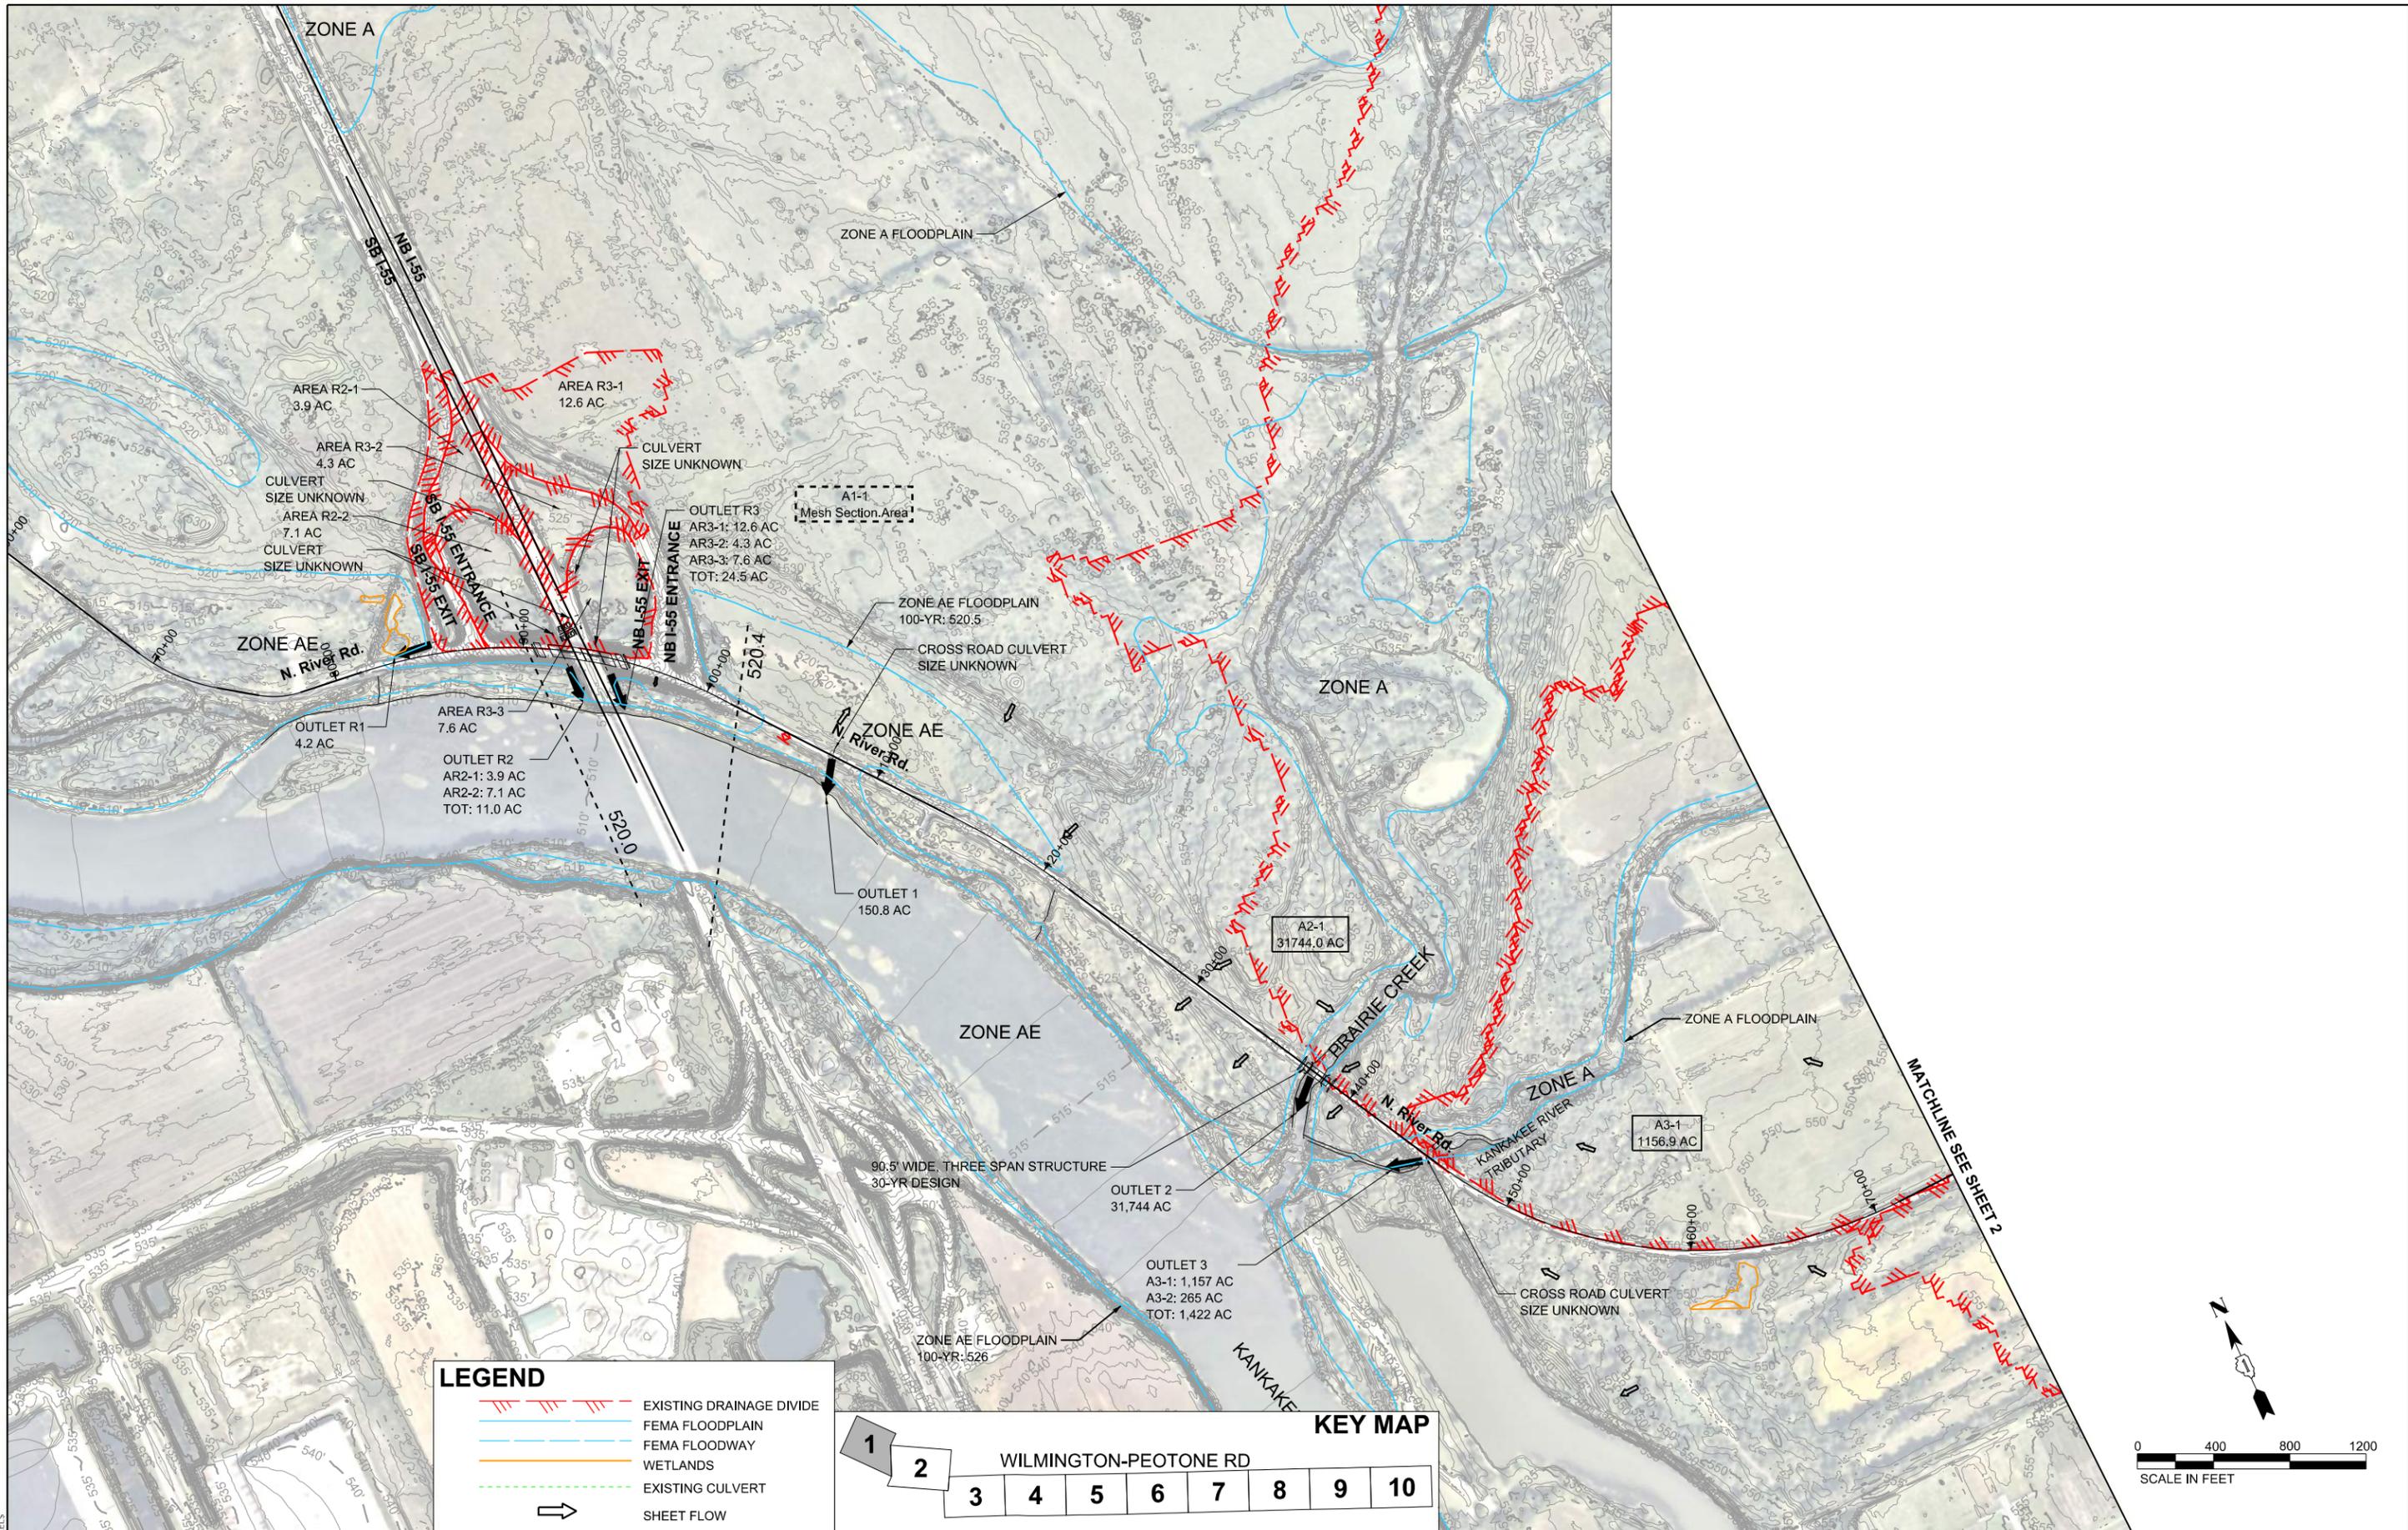


Exhibit 5F: Existing Drainage Plan

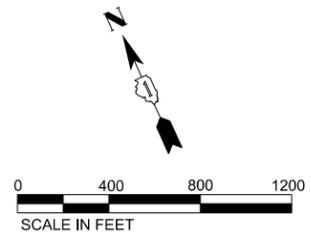

LEGEND

	EXISTING DRAINAGE DIVIDE
	FEMA FLOODPLAIN
	FEMA FLOODWAY
	WETLANDS
	EXISTING CULVERT
	SHEET FLOW

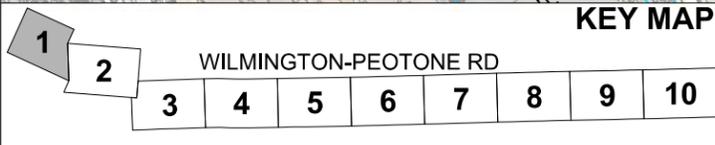

MODEL: S:\PROJECTS\WILMINGTON-PEOTONE\FILE NAMES: SHEETS

USER NAME = \$USERS	DESIGNED -	REVISED -
PLOT SCALE = \$SCALE	DRAWN -	REVISED -
PLOT DATE = \$DATE	CHECKED -	REVISED -
	DATE -	REVISED -

**WILL COUNTY
DIVISION OF TRANSPORTATION**

**PRELIMINARY EXISTING DRAINAGE PLAN
WILMINGTON-PEOTONE ROAD**

SCALE: 1"=400' SHEET OF SHEETS STA. TO STA.

F.A.S. RTE. 357	SECTION	COUNTY WILL	TOTAL SHEETS 10	SHEET NO. 1
CONTRACT NO. 159646				
ILLINOIS FED. AID PROJECT				




MATCHLINE SEE SHEET 1

MATCHLINE SEE SHEET 3



LEGEND	
	EXISTING DRAINAGE DIVIDE
	FEMA FLOODPLAIN
	FEMA FLOODWAY
	WETLANDS
	EXISTING CULVERT
	SHEET FLOW

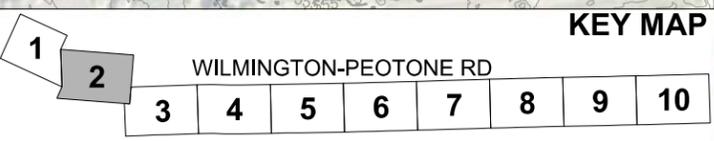

USER NAME = \$USERS	DESIGNED -	REVISED -
	DRAWN -	REVISED -
PLOT SCALE = \$SCALES	CHECKED -	REVISED -
PLOT DATE = \$DATES	DATE -	REVISED -

**WILL COUNTY
DIVISION OF TRANSPORTATION**


**PRELIMINARY EXISTING DRAINAGE PLAN
WILMINGTON-PEOTONE ROAD**

SCALE: 1"=400' SHEET OF SHEETS STA. TO STA.

F.A.S RTE. 357	SECTION	COUNTY	TOTAL SHEETS	SHEET NO.
	SECTION	WILL	10	2
CONTRACT NO. 159646				
ILLINOIS FED. AID PROJECT				

MODEL: \$MODELNAME\$
FILE: \$NAME\$. \$FILETYPE\$

MODEL: \\M:\P\06-06-EX - EDP-1 (5/24/24)
 FILE NAME: \\P\06-06-EX - EDP-1 (5/24/24) - 159646.dwg

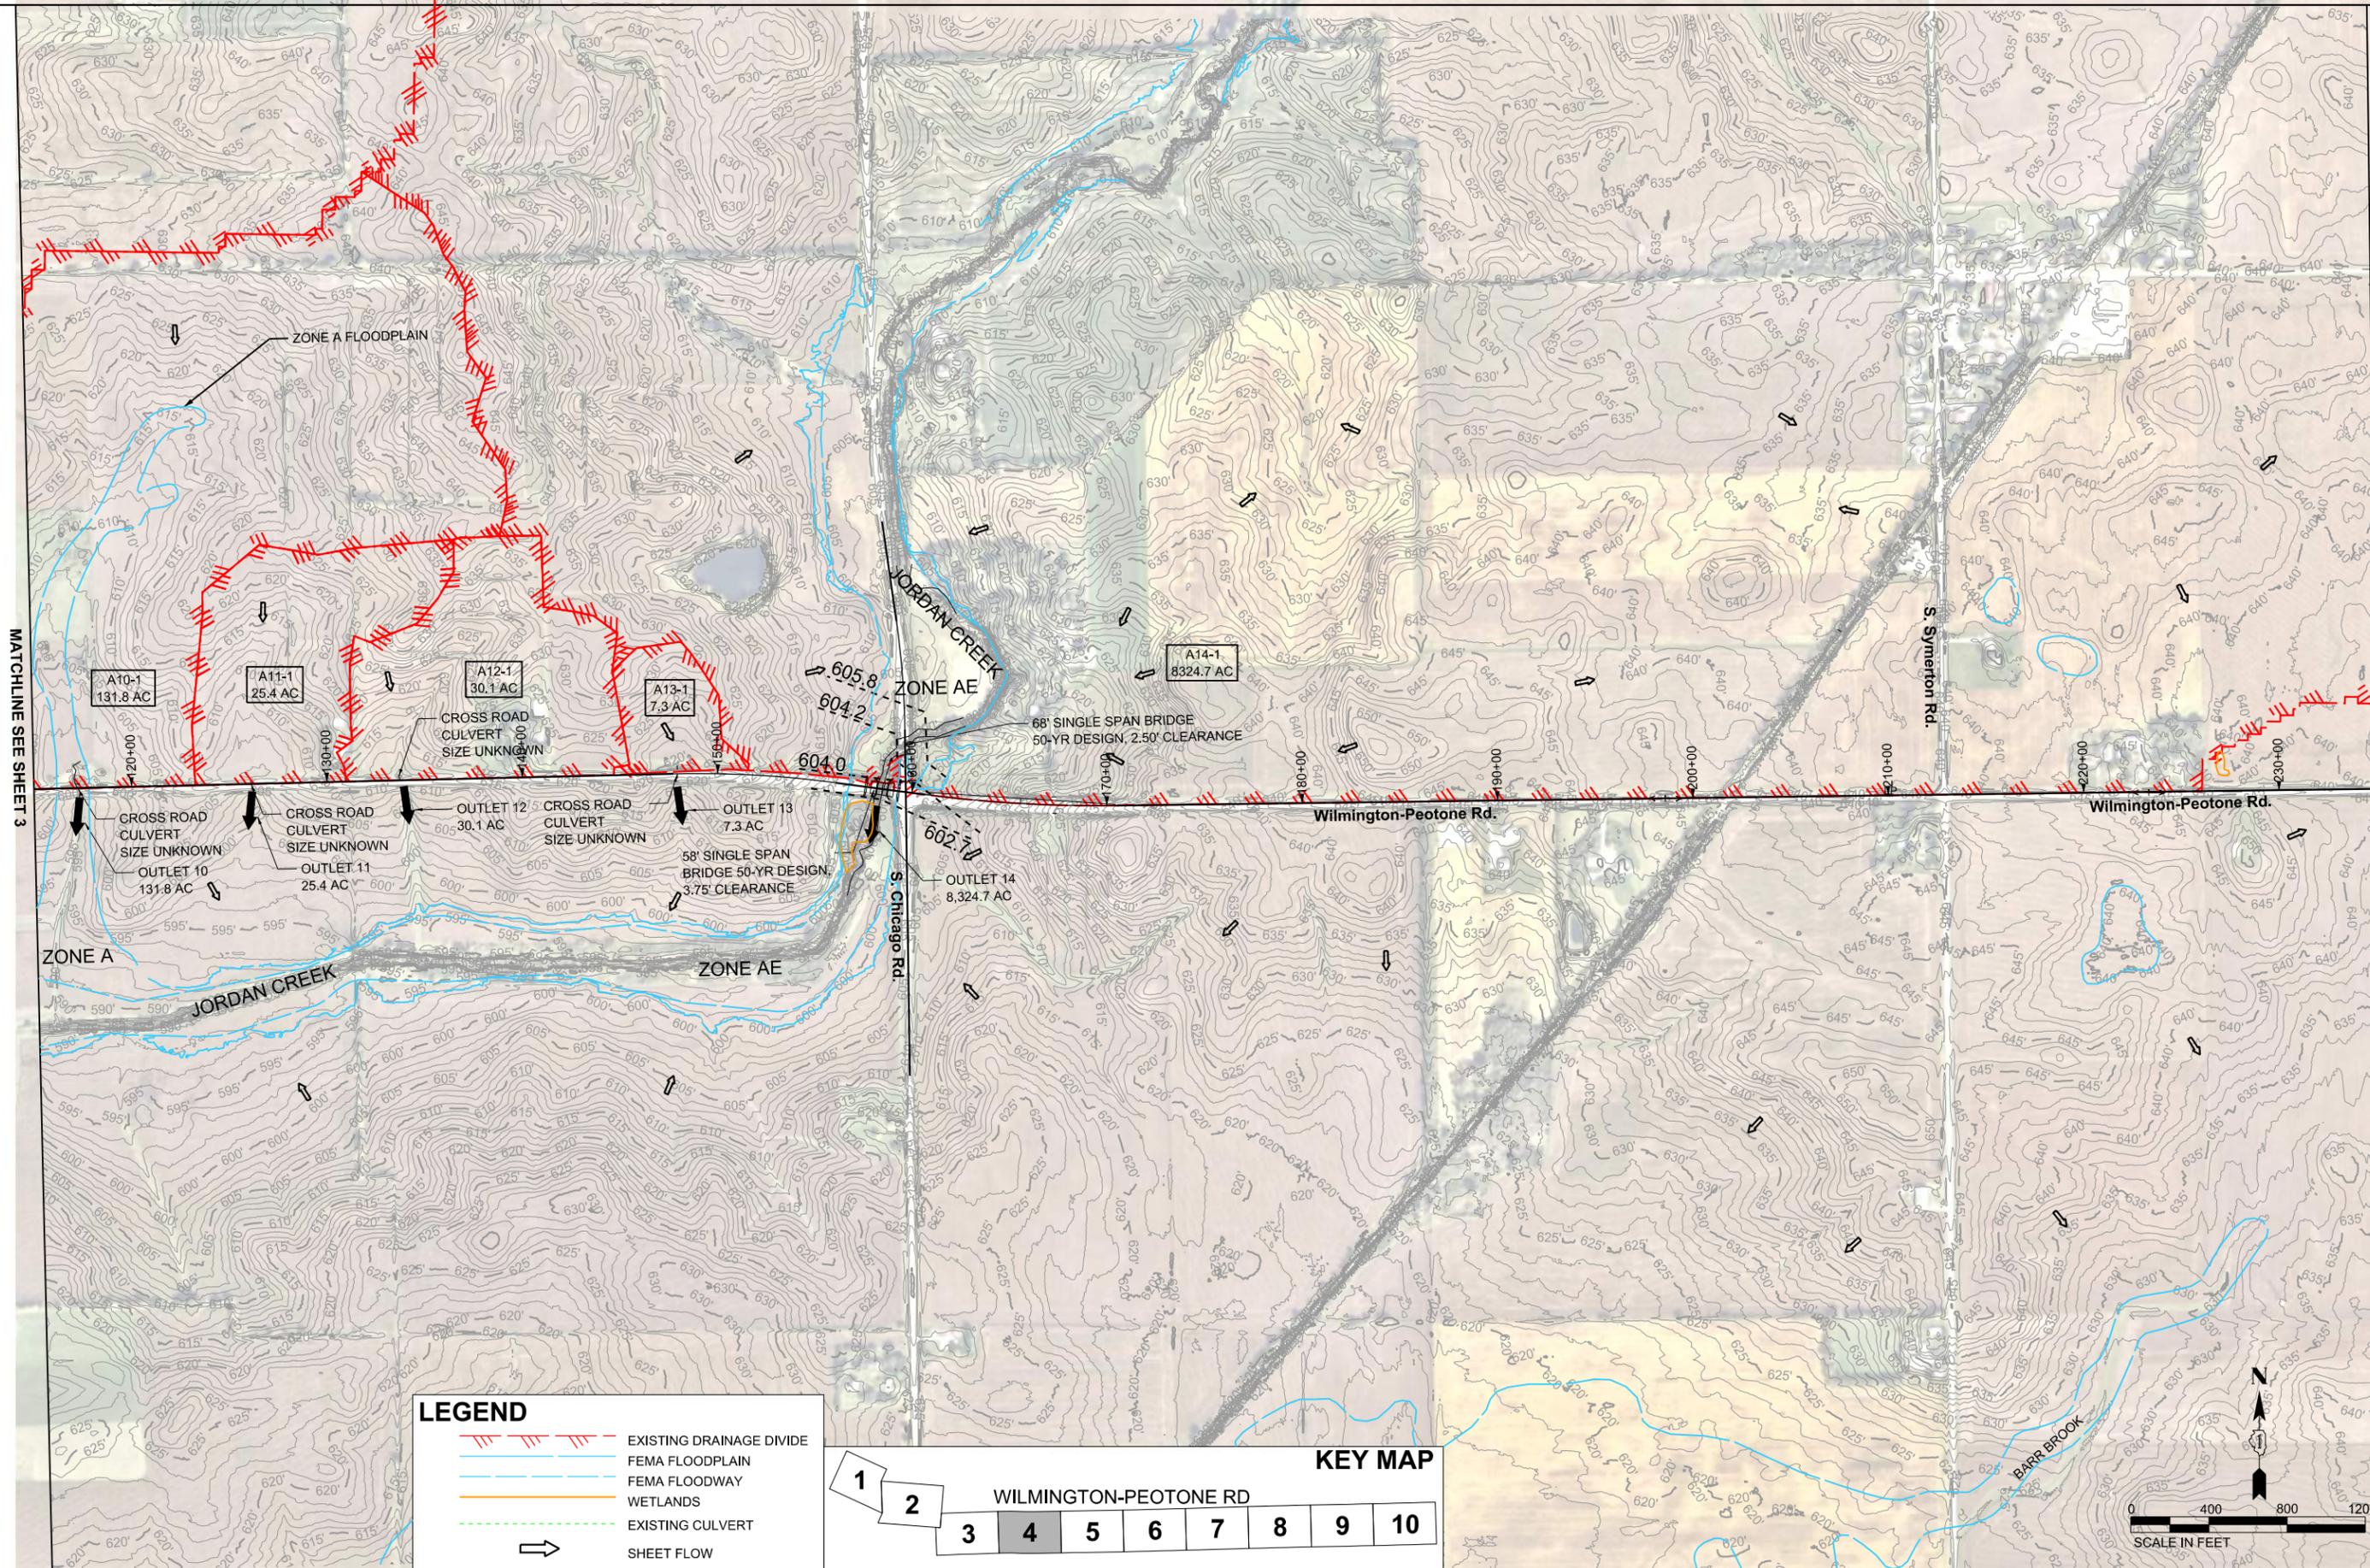


MATCHLINE SEE SHEET 3

MATCHLINE SEE SHEET 5

LEGEND

	EXISTING DRAINAGE DIVIDE
	FEMA FLOODPLAIN
	FEMA FLOODWAY
	WETLANDS
	EXISTING CULVERT
	SHEET FLOW

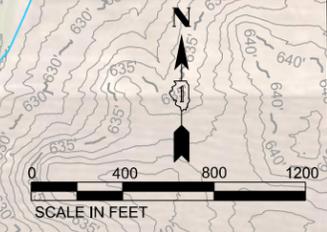

USER NAME = jrueda	DESIGNED -	REVISED -
	DRAWN -	REVISED -
PLOT SCALE = 0.16666633' / in.	CHECKED -	REVISED -
PLOT DATE = 5/22/2024	DATE -	REVISED -

**WILL COUNTY
 DIVISION OF TRANSPORTATION**

**PRELIMINARY EXISTING DRAINAGE PLAN
 WILMINGTON-PEOTONE ROAD**


SCALE: 1"=400' SHEET OF SHEETS STA. TO STA.

F.A.S. RTE. 357	SECTION	COUNTY WILL	TOTAL SHEETS 10	SHEET NO. 4
ILLINOIS FED. AID PROJECT			CONTRACT NO. 159646	

MODEL: \\M:\P\06-C-EX - EDP-2 (Sheet)
 FILE: \\M:\P\06-C-EX - EDP-2 (Sheet)\03\Documents\159646_WilmingtonPeotoneRd\159646_Sheet_Layout_DWG


MATCHLINE SEE SHEET 4

MATCHLINE SEE SHEET 6

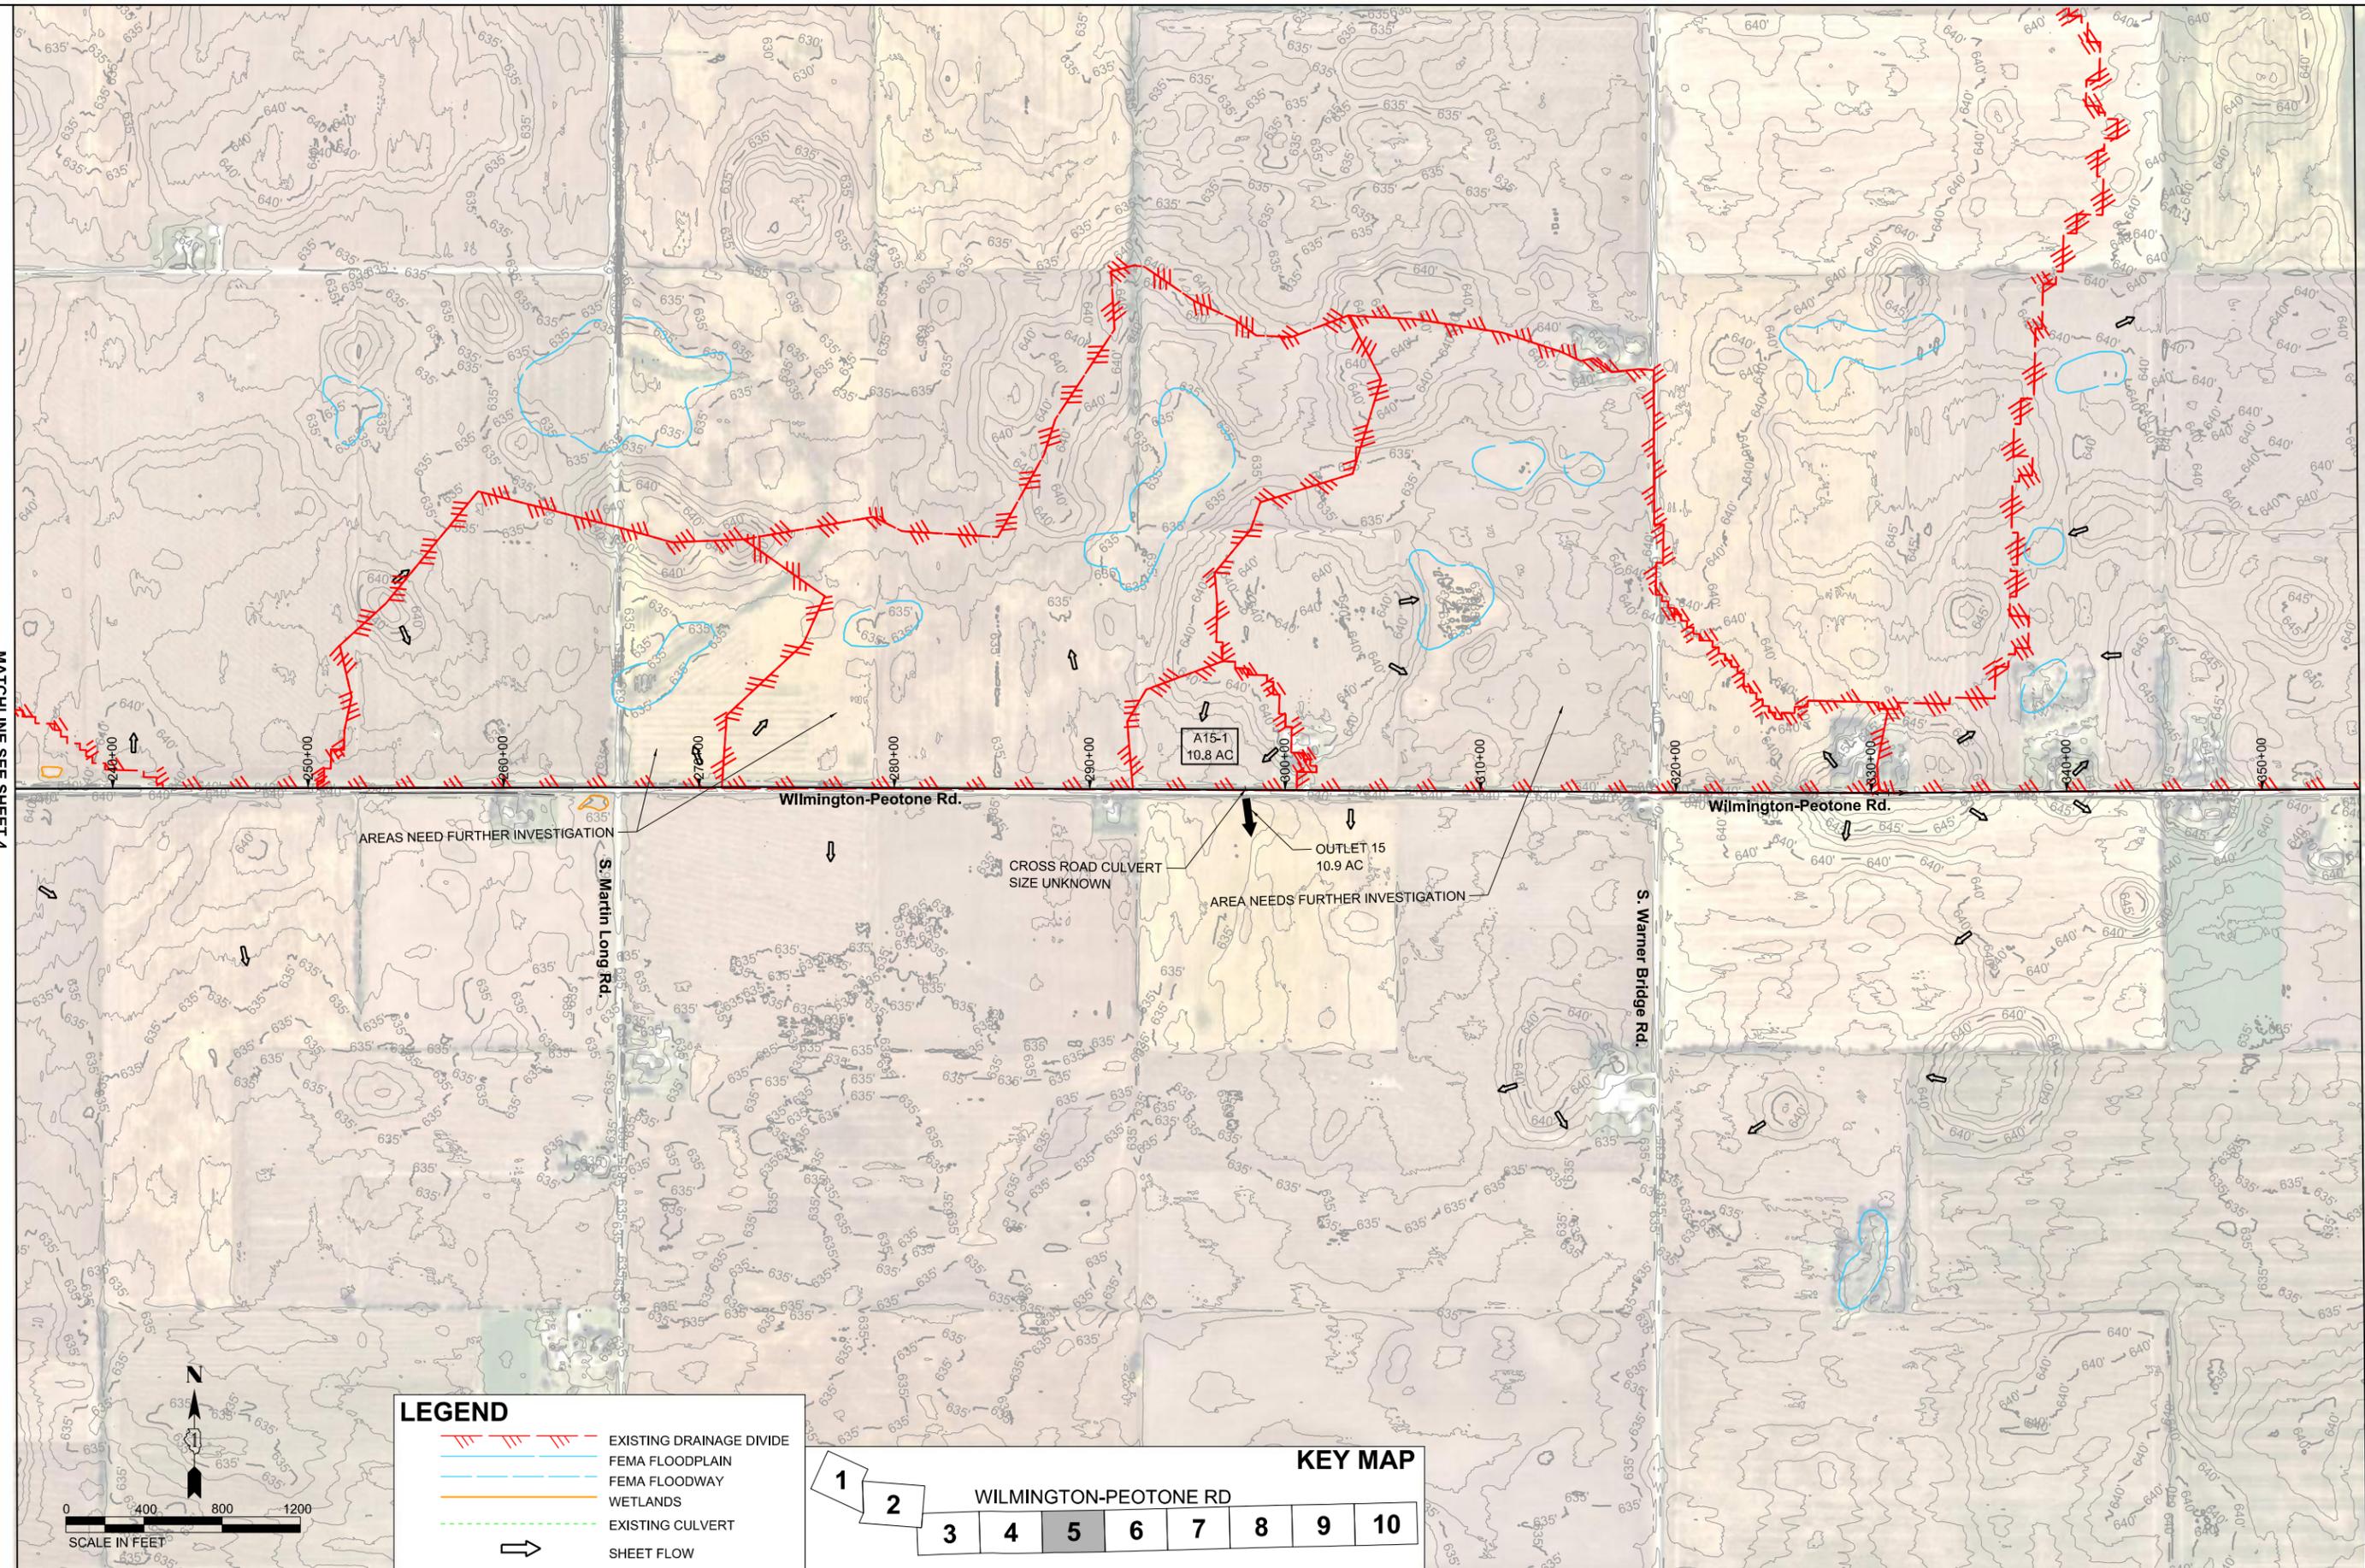

LEGEND

 - EXISTING DRAINAGE DIVIDE
- FEMA FLOODPLAIN
- FEMA FLOODWAY
- WETLANDS
- EXISTING CULVERT
- SHEET FLOW



USER NAME = jrueda	DESIGNED -	REVISED -
	DRAWN -	REVISED -
PLOT SCALE = 0.16666633' / in.	CHECKED -	REVISED -
PLOT DATE = 5/22/2024	DATE -	REVISED -


**WILL COUNTY
 DIVISION OF TRANSPORTATION**

**PRELIMINARY EXISTING DRAINAGE PLAN
 WILMINGTON-PEOTONE ROAD**

SCALE: 1"=400' SHEET OF SHEETS STA. TO STA.

F.A.S RTE. 357	SECTION	COUNTY WILL	TOTAL SHEETS 10	SHEET NO. 5
ILLINOIS FED. AID PROJECT			CONTRACT NO. 159646	

MODEL: \\P:\P\06-06-24\EDP-3\Sheet1.dwg
 FILE: \\P:\P\06-06-24\EDP-3\Sheet1.dwg
 USER: jrueda
 DATE: 5/22/2024

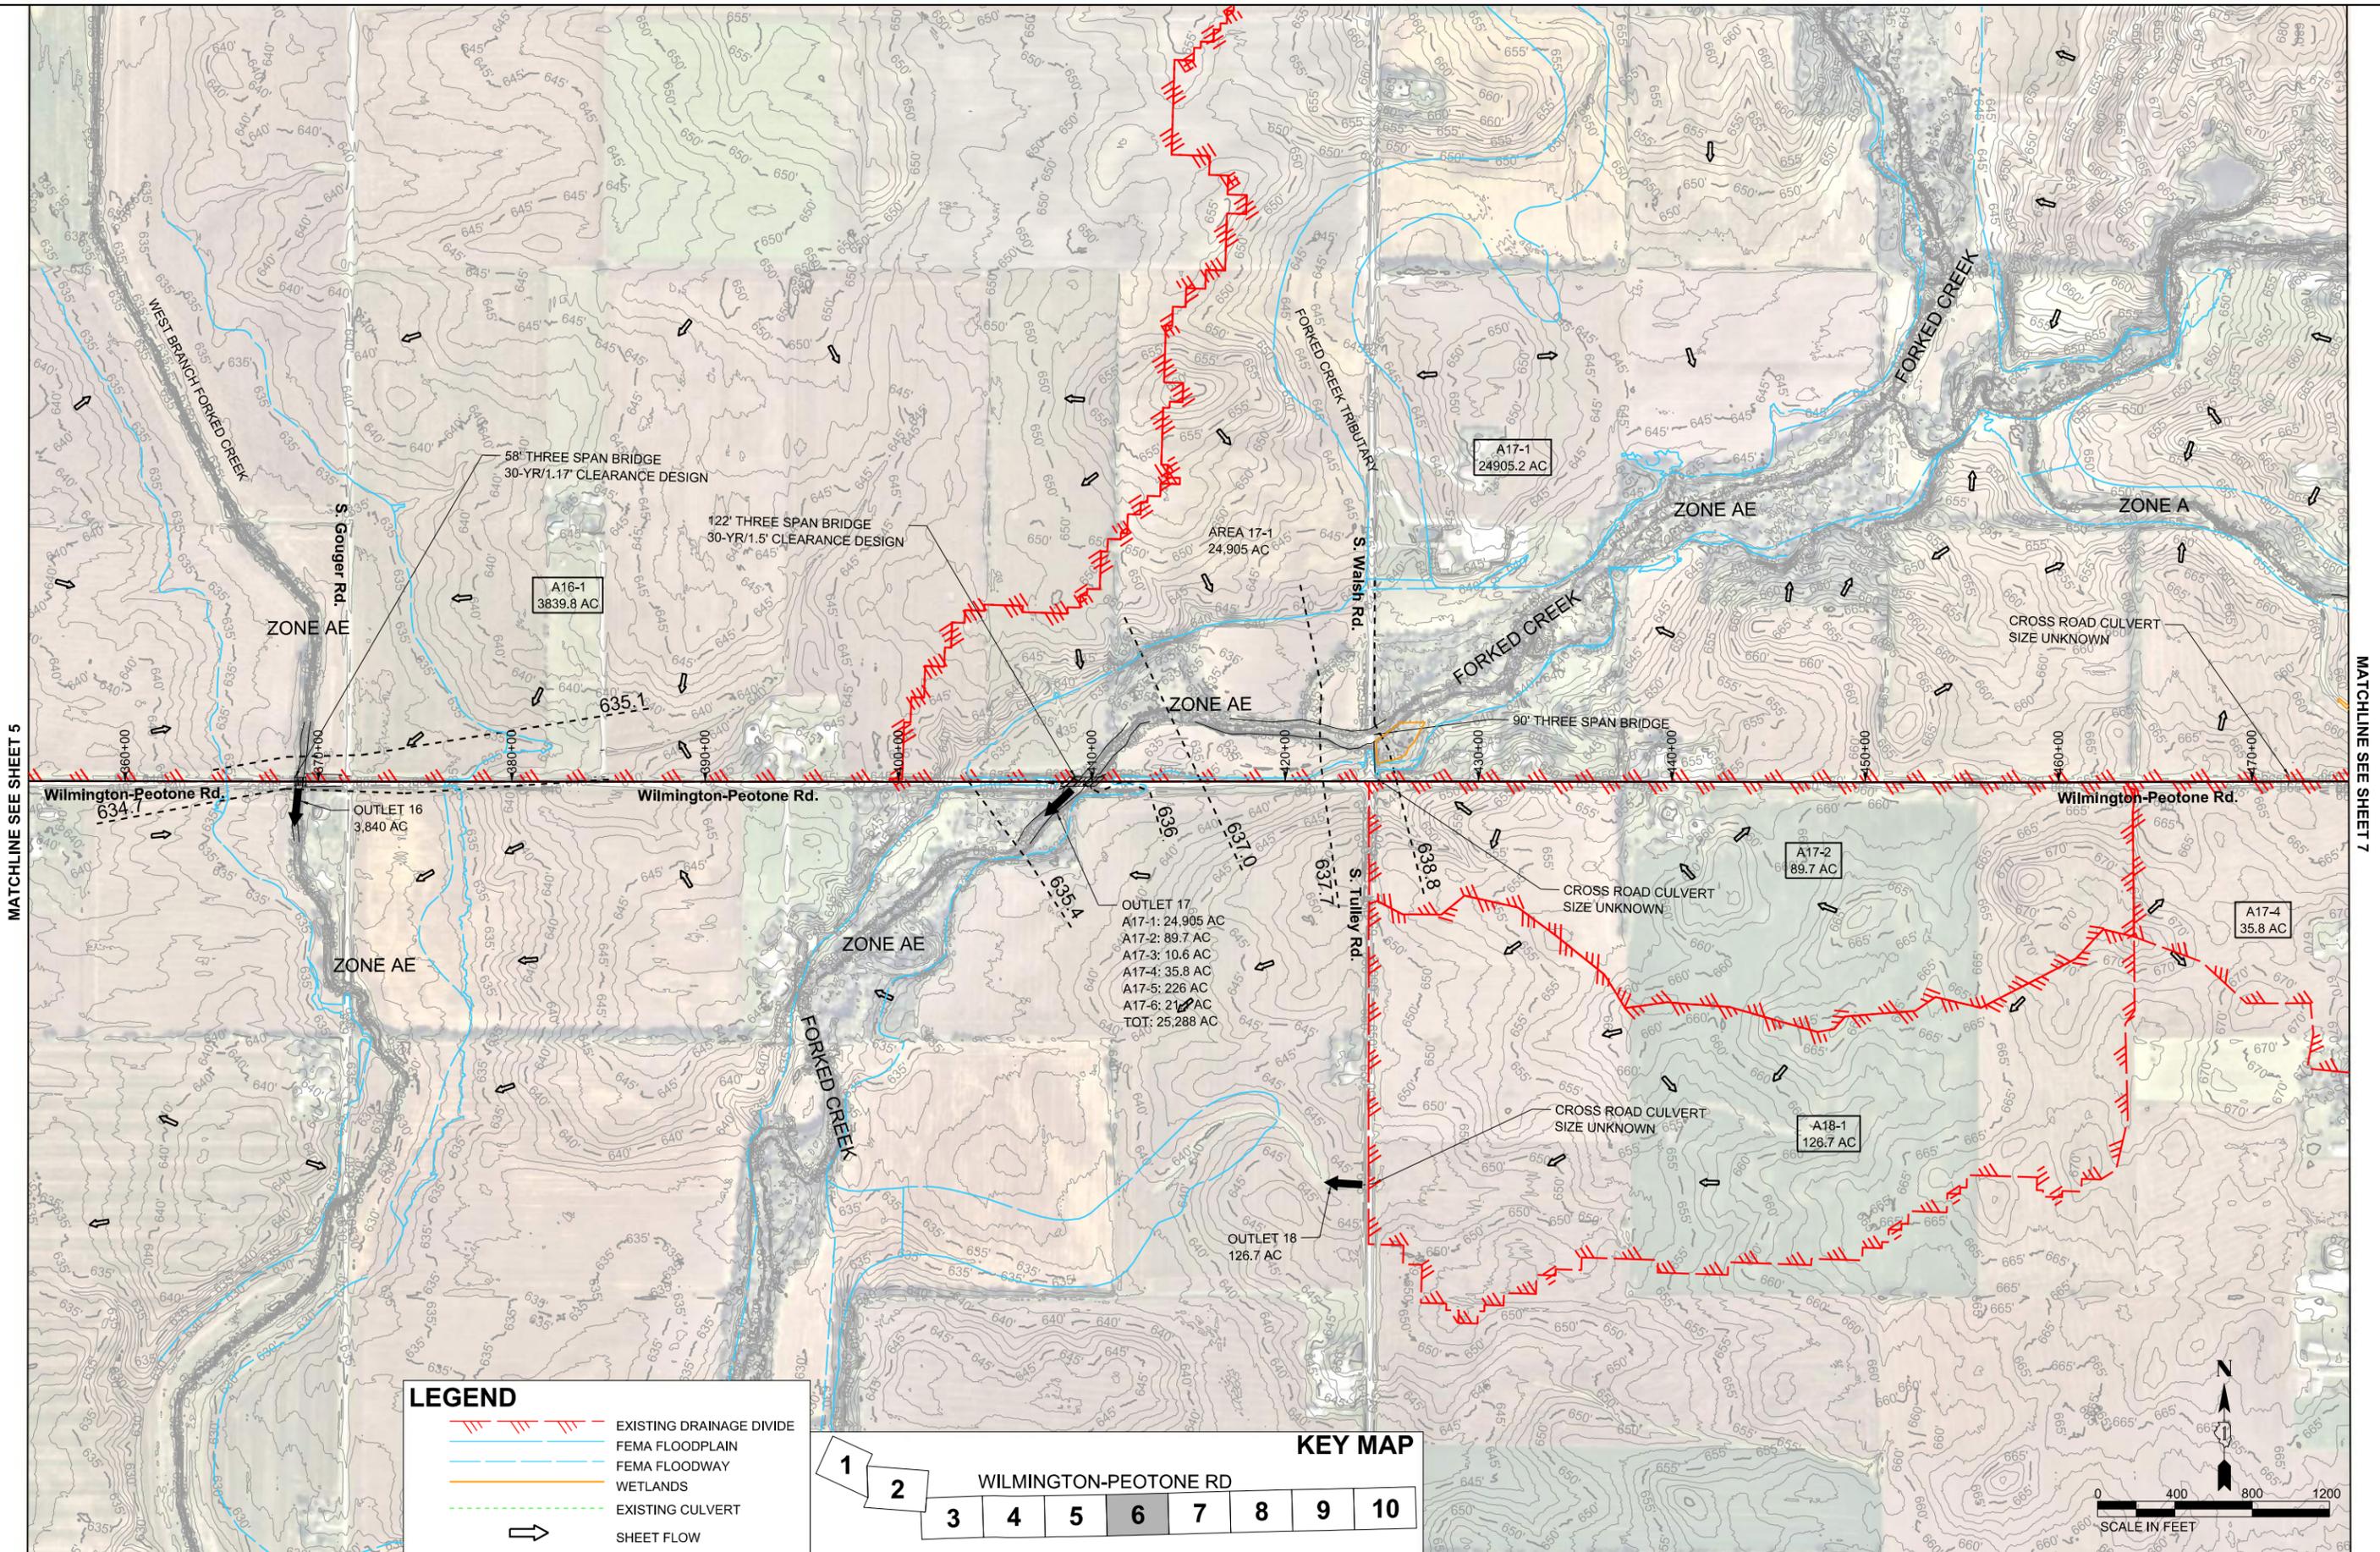


MATCHLINE SEE SHEET 5

MATCHLINE SEE SHEET 7

LEGEND

	EXISTING DRAINAGE DIVIDE
	FEMA FLOODPLAIN
	FEMA FLOODWAY
	WETLANDS
	EXISTING CULVERT
	SHEET FLOW

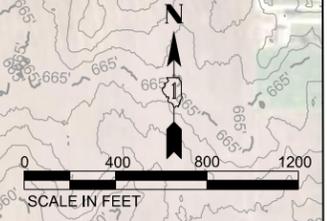

USER NAME = jrueda	DESIGNED -	REVISED -
	DRAWN -	REVISED -
PLOT SCALE = 0.16666633' / in.	CHECKED -	REVISED -
PLOT DATE = 5/22/2024	DATE -	REVISED -


**WILL COUNTY
 DIVISION OF TRANSPORTATION**

**PRELIMINARY EXISTING DRAINAGE PLAN
 WILMINGTON-PEOTONE ROAD**

SCALE: 1"=400' SHEET OF SHEETS STA. TO STA.

F.A.S. RTE. 357	SECTION	COUNTY WILL	TOTAL SHEETS 10	SHEET NO. 6
CONTRACT NO. 159646				
ILLINOIS FED. AID PROJECT				

MODEL: \\N:\P\06-06-24-EDP4-15\150401
 FILE: NAME: \\P\06-06-24-EDP4-15\150401\150401.dwg

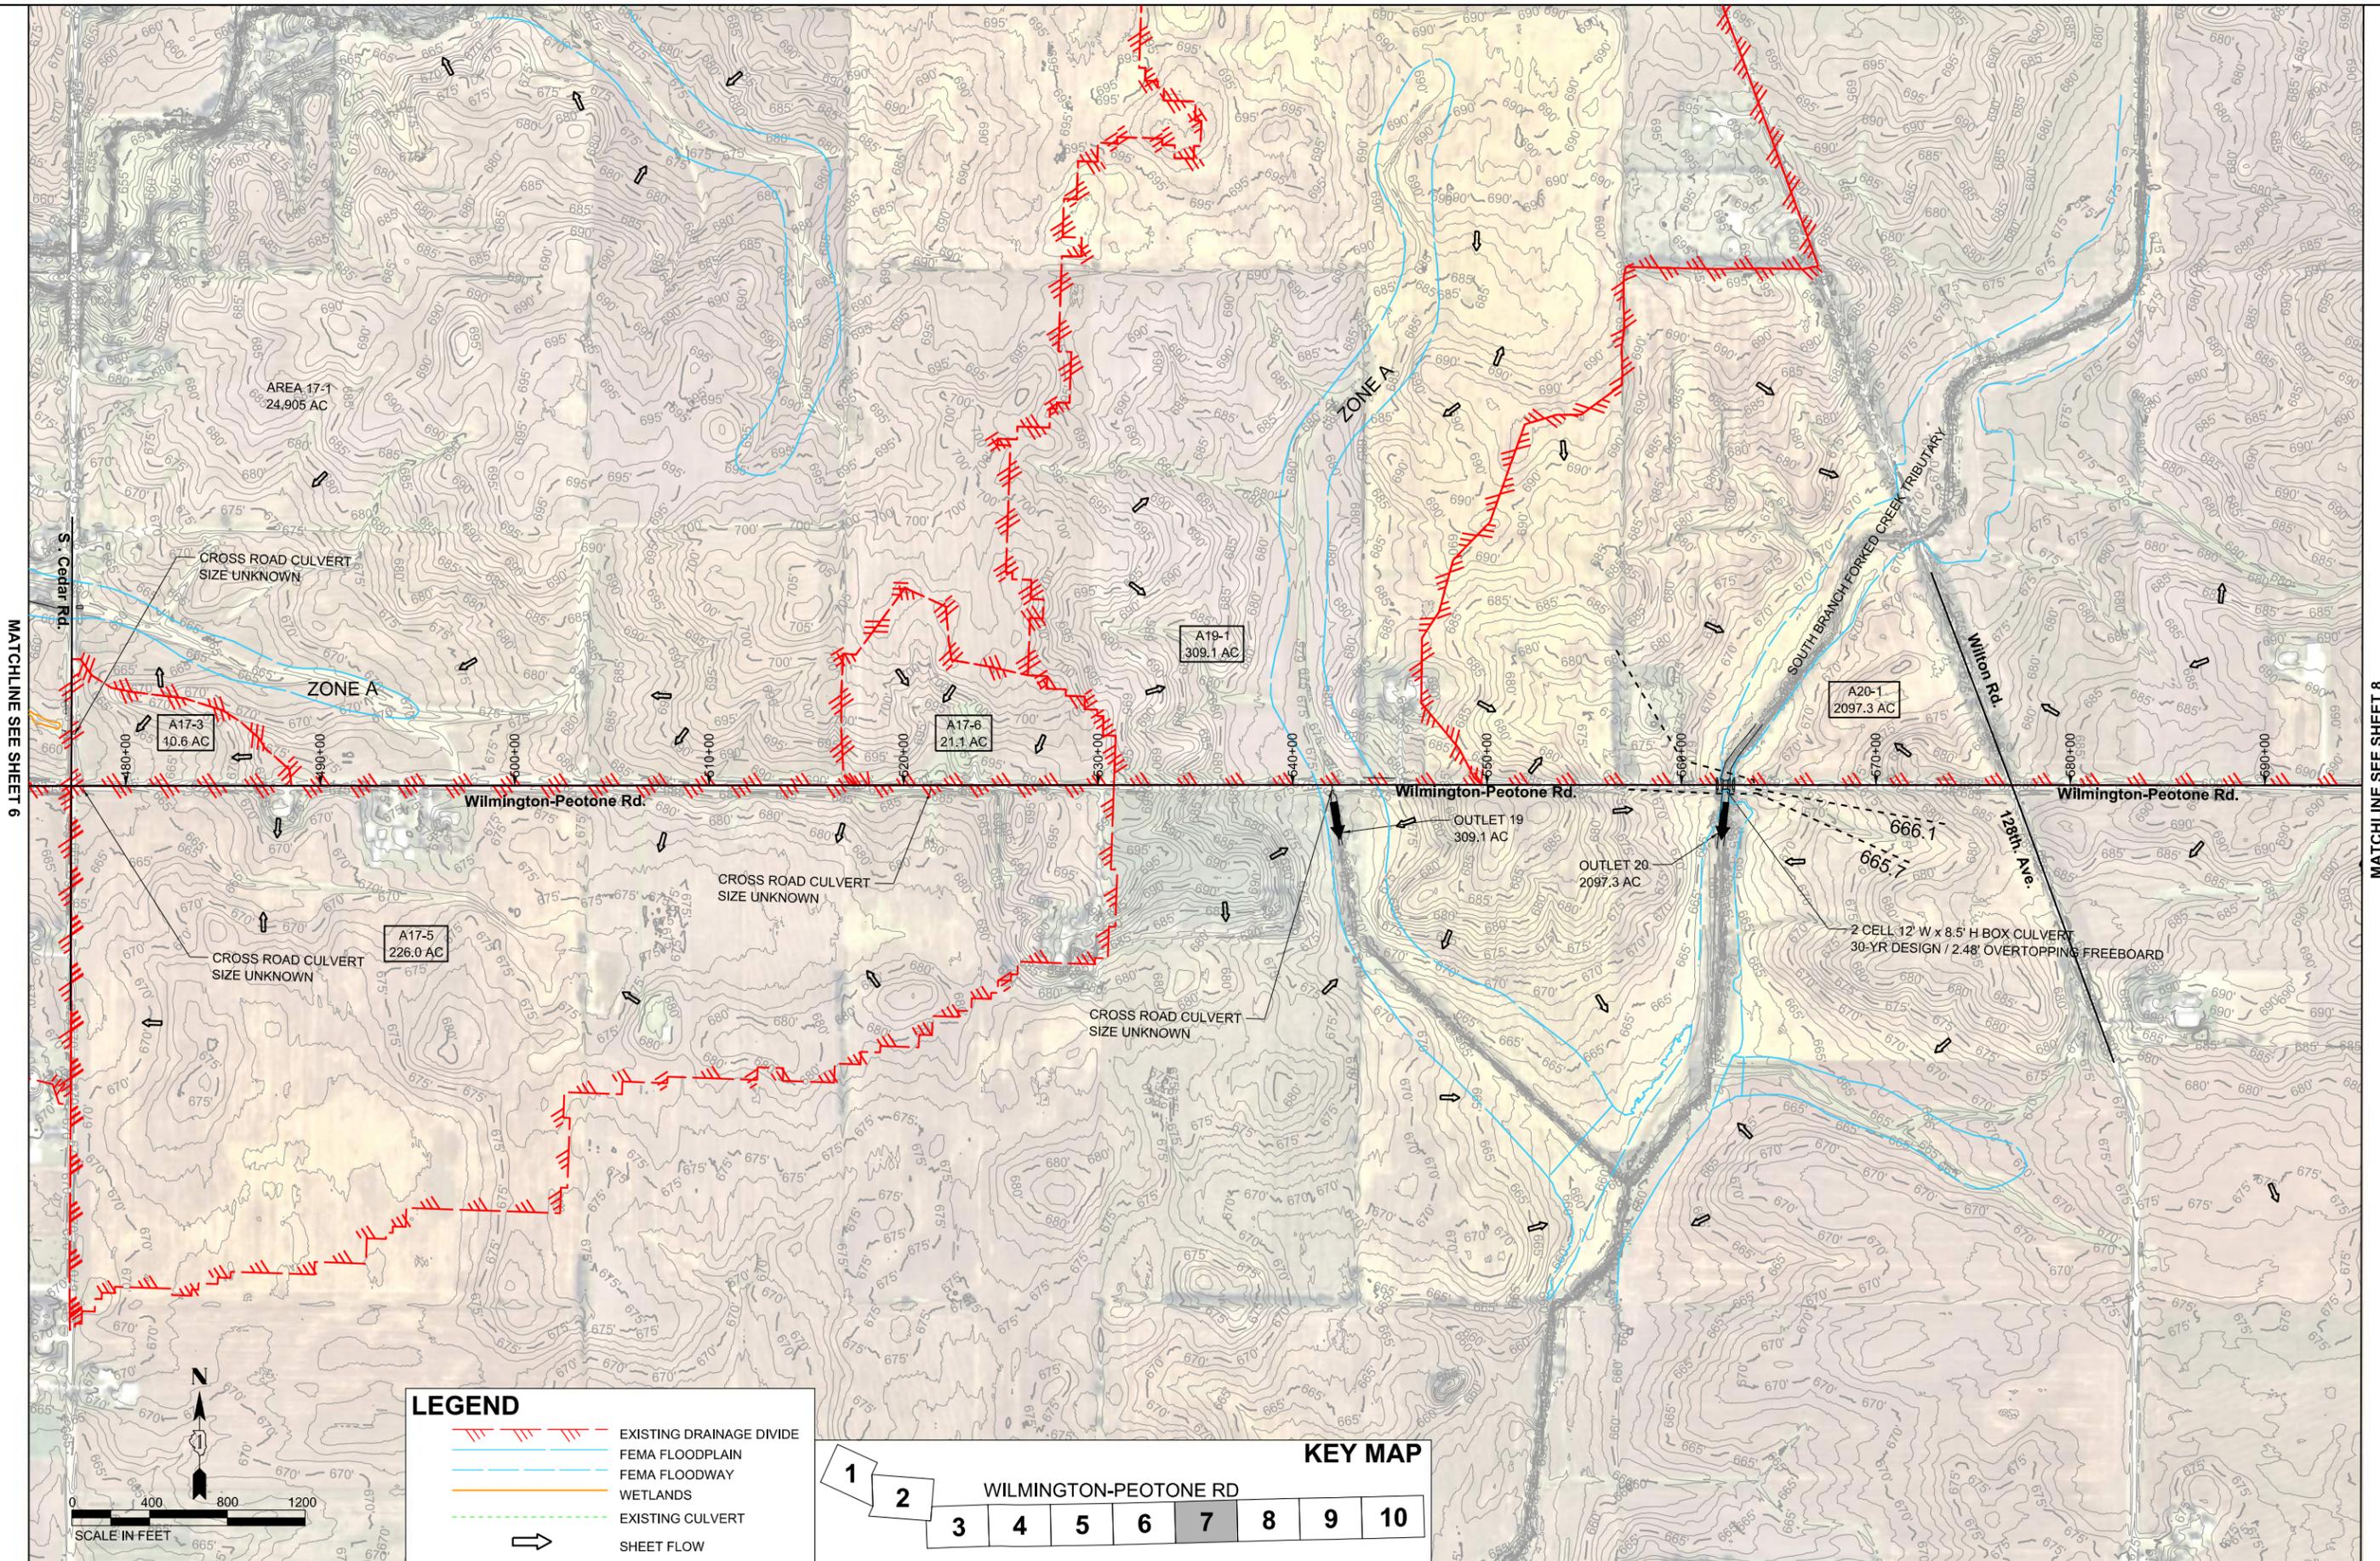

LEGEND

- EXISTING DRAINAGE DIVIDE
- FEMA FLOODPLAIN
- FEMA FLOODWAY
- WETLANDS
- EXISTING CULVERT
- SHEET FLOW



USER NAME = jrueda	DESIGNED -	REVISED -
	DRAWN -	REVISED -
PLOT SCALE = 0.16666633' / in.	CHECKED -	REVISED -
PLOT DATE = 5/22/2024	DATE -	REVISED -


**WILL COUNTY
 DIVISION OF TRANSPORTATION**

**PRELIMINARY EXISTING DRAINAGE PLAN
 WILMINGTON-PEOTONE ROAD**

SCALE: 1"=400' SHEET OF SHEETS STA. TO STA.

F.A.S. RTE. 357	SECTION	COUNTY WILL	TOTAL SHEETS 10	SHEET NO. 7
			CONTRACT NO. 159646	
ILLINOIS FED. AID PROJECT				

MODEL: \\N:\PE\A-C\EX - EDP\5 - (5)441
 FILE NAME: \\N:\PE\A-C\EX - EDP\5 - (5)441\159646_159646_Sheet_Layout_DWG

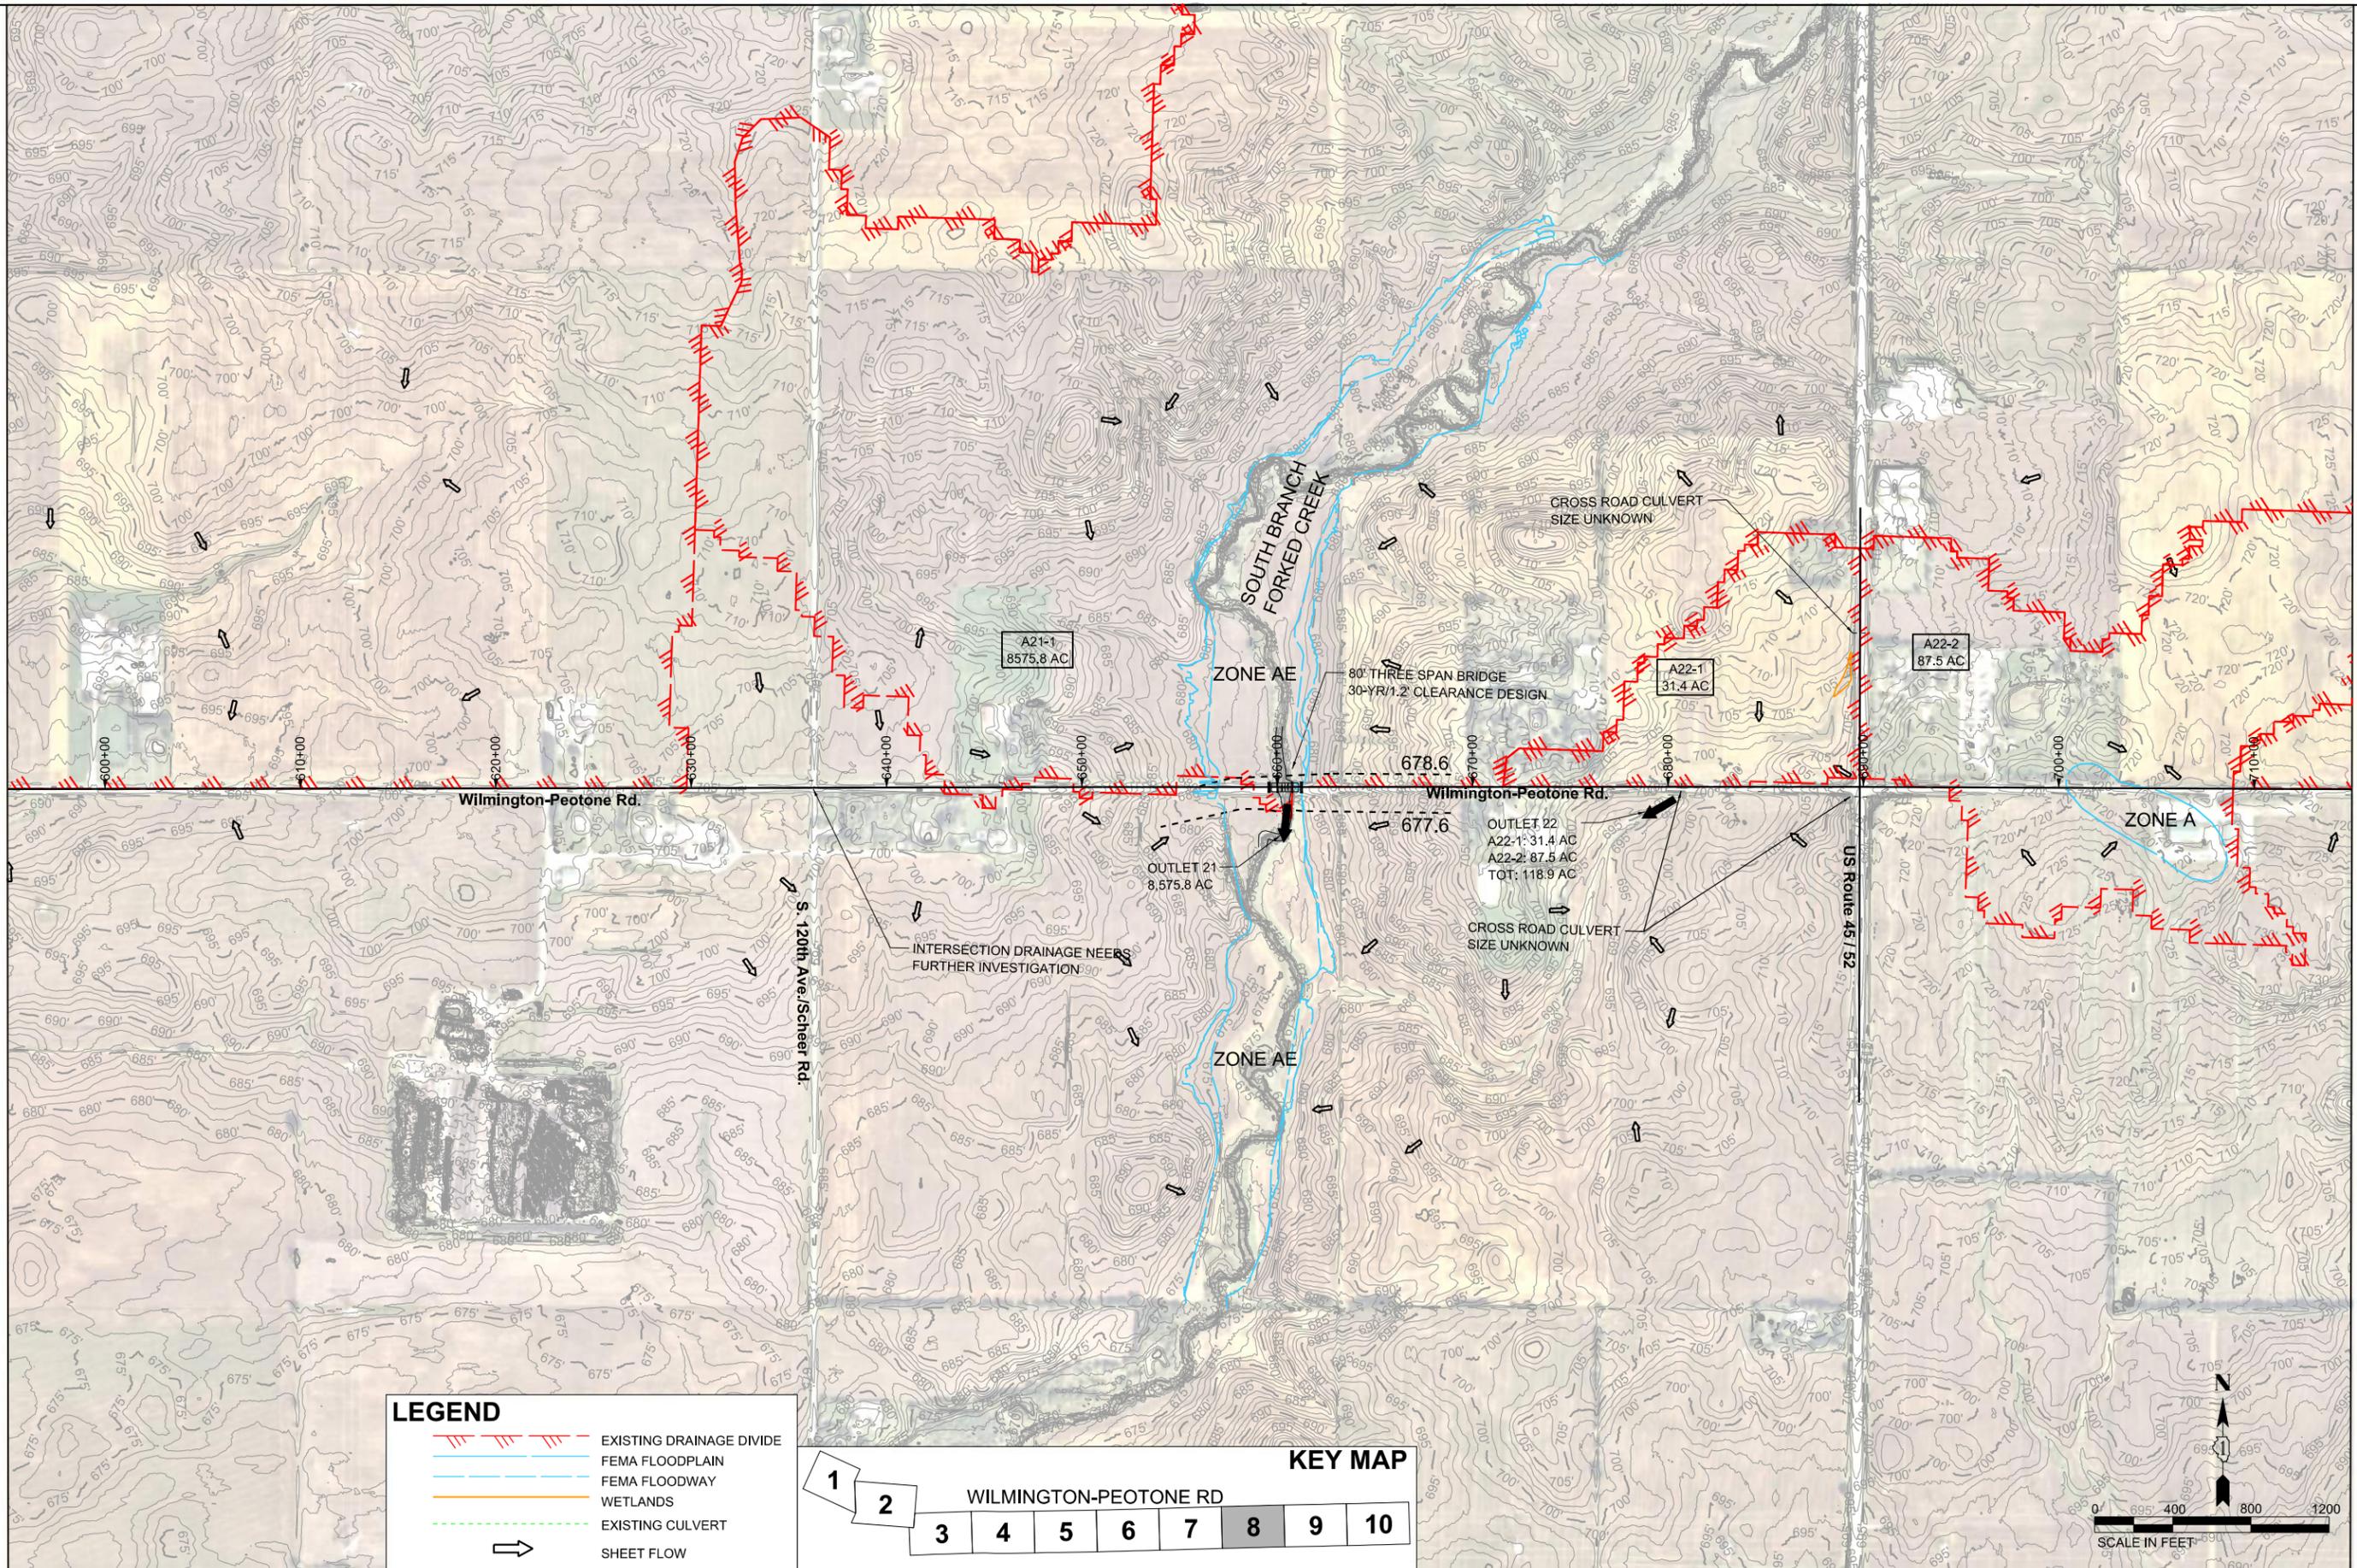

LEGEND

- EXISTING DRAINAGE DIVIDE
- FEMA FLOODPLAIN
- FEMA FLOODWAY
- WETLANDS
- EXISTING CULVERT
- SHEET FLOW

KEY MAP

1 2 3 4 5 6 7 8 9 10

WILMINGTON-PEOTONE RD

USER NAME = jrueda	DESIGNED -	REVISED -
	DRAWN -	REVISED -
PLOT SCALE = 0.16666633' / in.	CHECKED -	REVISED -
PLOT DATE = 5/22/2024	DATE -	REVISED -

**WILL COUNTY
 DIVISION OF TRANSPORTATION**

**PRELIMINARY EXISTING DRAINAGE PLAN
 WILMINGTON-PEOTONE ROAD**


SCALE: 1"=400' SHEET OF SHEETS STA. TO STA.

F.A.S. RTE. 357	SECTION	COUNTY WILL	TOTAL SHEETS 10	SHEET NO. 8
			CONTRACT NO. 159646	
ILLINOIS FED. AID PROJECT				


MATCHLINE SEE SHEET 9

MODEL: \\P:\PC-A-C-EX - EDP-7 (Sheet) 1
 FILE: \\P:\PC-A-C-EX - EDP-7 (Sheet) 1\Drawings\Wilmington-Peotone\ELC\add\Exhibits\Drawings\159646_Sheet_Layout_DWG

MATCHLINE SEE SHEET 9

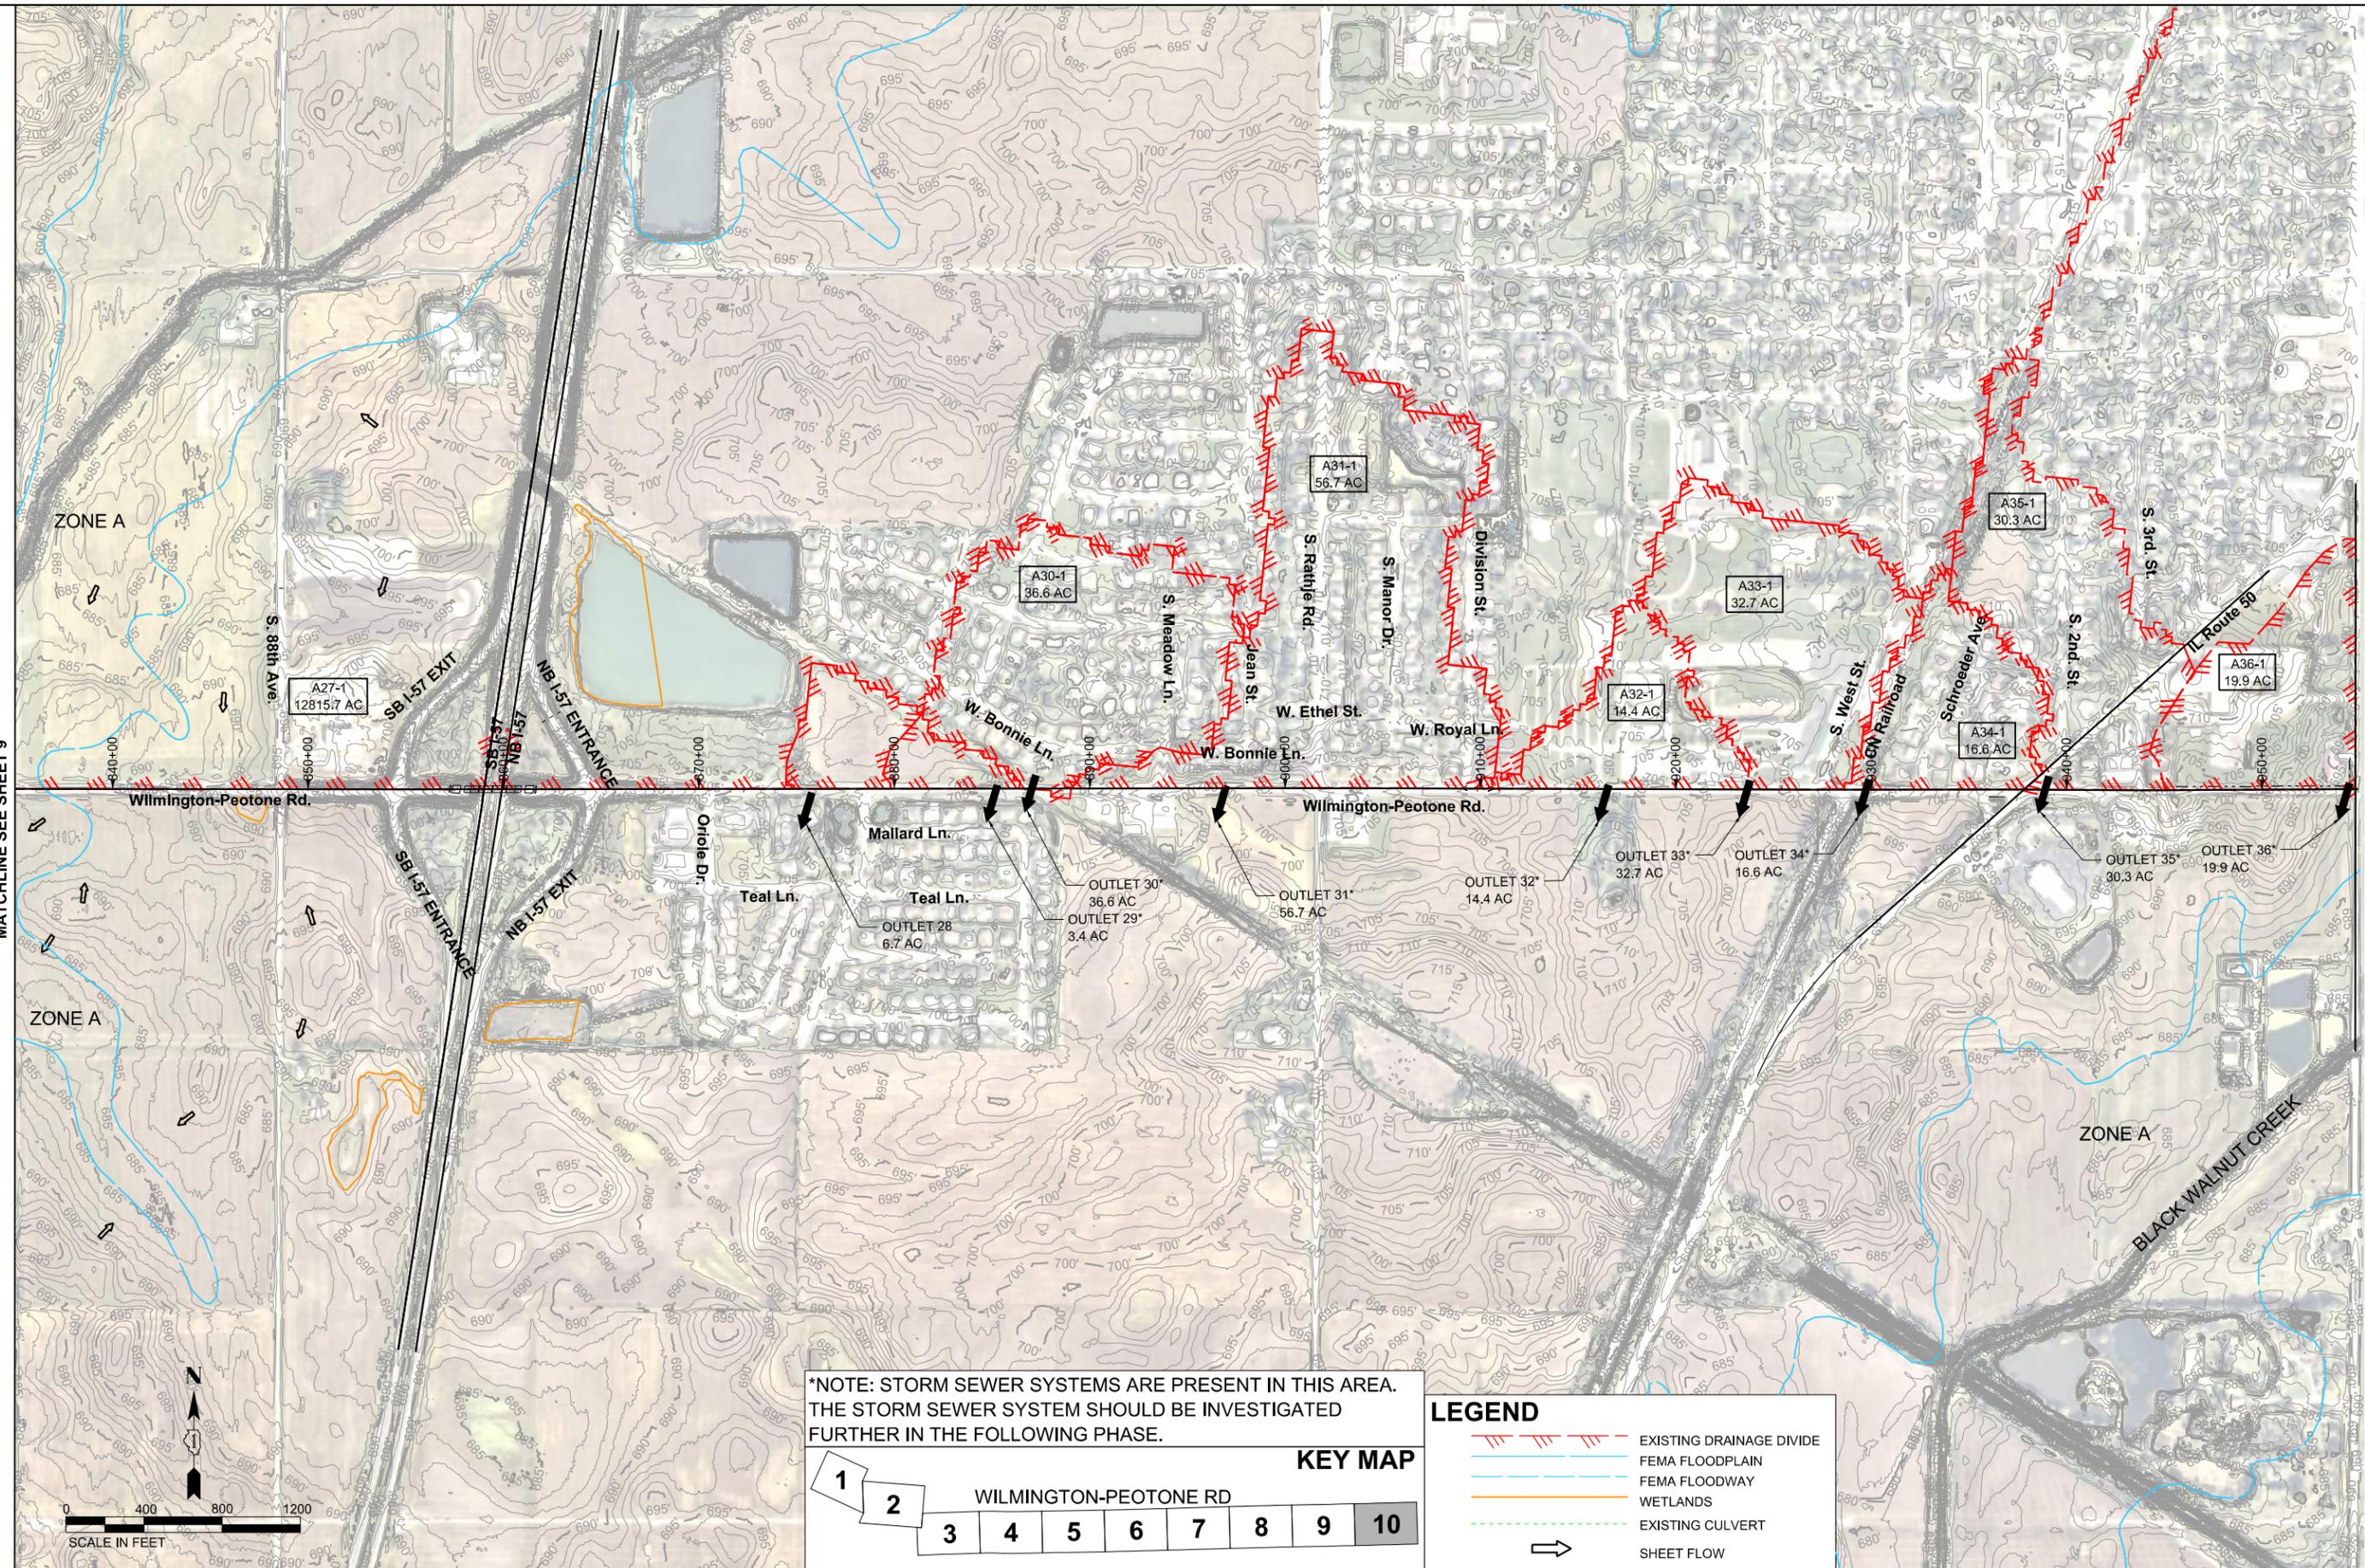

*NOTE: STORM SEWER SYSTEMS ARE PRESENT IN THIS AREA. THE STORM SEWER SYSTEM SHOULD BE INVESTIGATED FURTHER IN THE FOLLOWING PHASE.

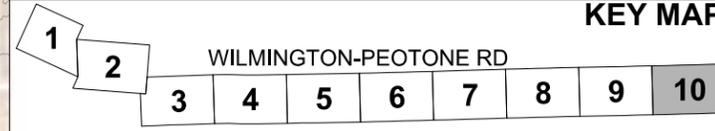

LEGEND

- EXISTING DRAINAGE DIVIDE
- FEMA FLOODPLAIN
- FEMA FLOODWAY
- WETLANDS
- EXISTING CULVERT
- SHEET FLOW



USER NAME = jrueda	DESIGNED -	REVISED -
	DRAWN -	REVISED -
PLOT SCALE = 0.16666633' / in.	CHECKED -	REVISED -
PLOT DATE = 5/22/2024	DATE -	REVISED -

**WILL COUNTY
DIVISION OF TRANSPORTATION**

**PRELIMINARY EXISTING DRAINAGE PLAN
WILMINGTON-PEOTONE ROAD**

SCALE: 1"=400'

SHEET OF SHEETS STA. TO STA.

F.A.S. RTE. 357	SECTION	COUNTY WILL	TOTAL SHEETS 10	SHEET NO. 10
CONTRACT NO. 159646			ILLINOIS FED. AID PROJECT	